
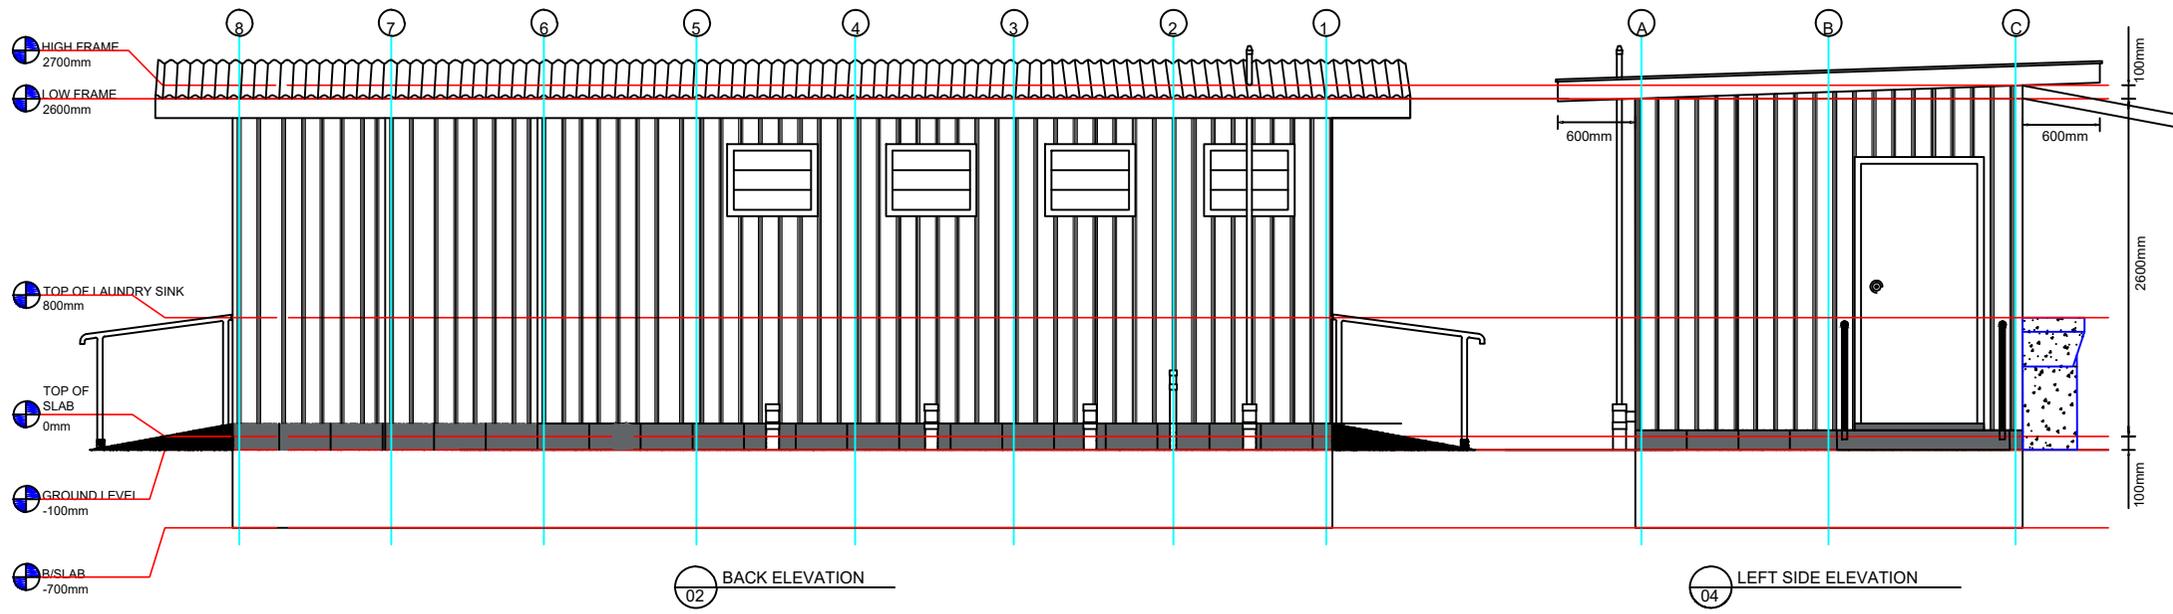







PLAN  
01

REV	DATE	BY	DESCRIPTION:	CLIENT:	CLIENT: UNICEF	SURVEY:	Scale: Not to scale
					PROJECT: KOICA- CLIMATE SMART	DESIGN: I.Q.BRIAN	SHEETS: 1 OF 6
					PROJECT LOCATION: GUADALCANAL PROVINCE	DRAWN: I.Q.BRIAN	SHEETS SIZE: A4
					SITE: NUMBU	REVISED: K.RODNEY	


**Ablution Standard Plan:**  
4 Toilet Cubicle and 3  
Shower room with 2 Exterior  
Laundry Sink

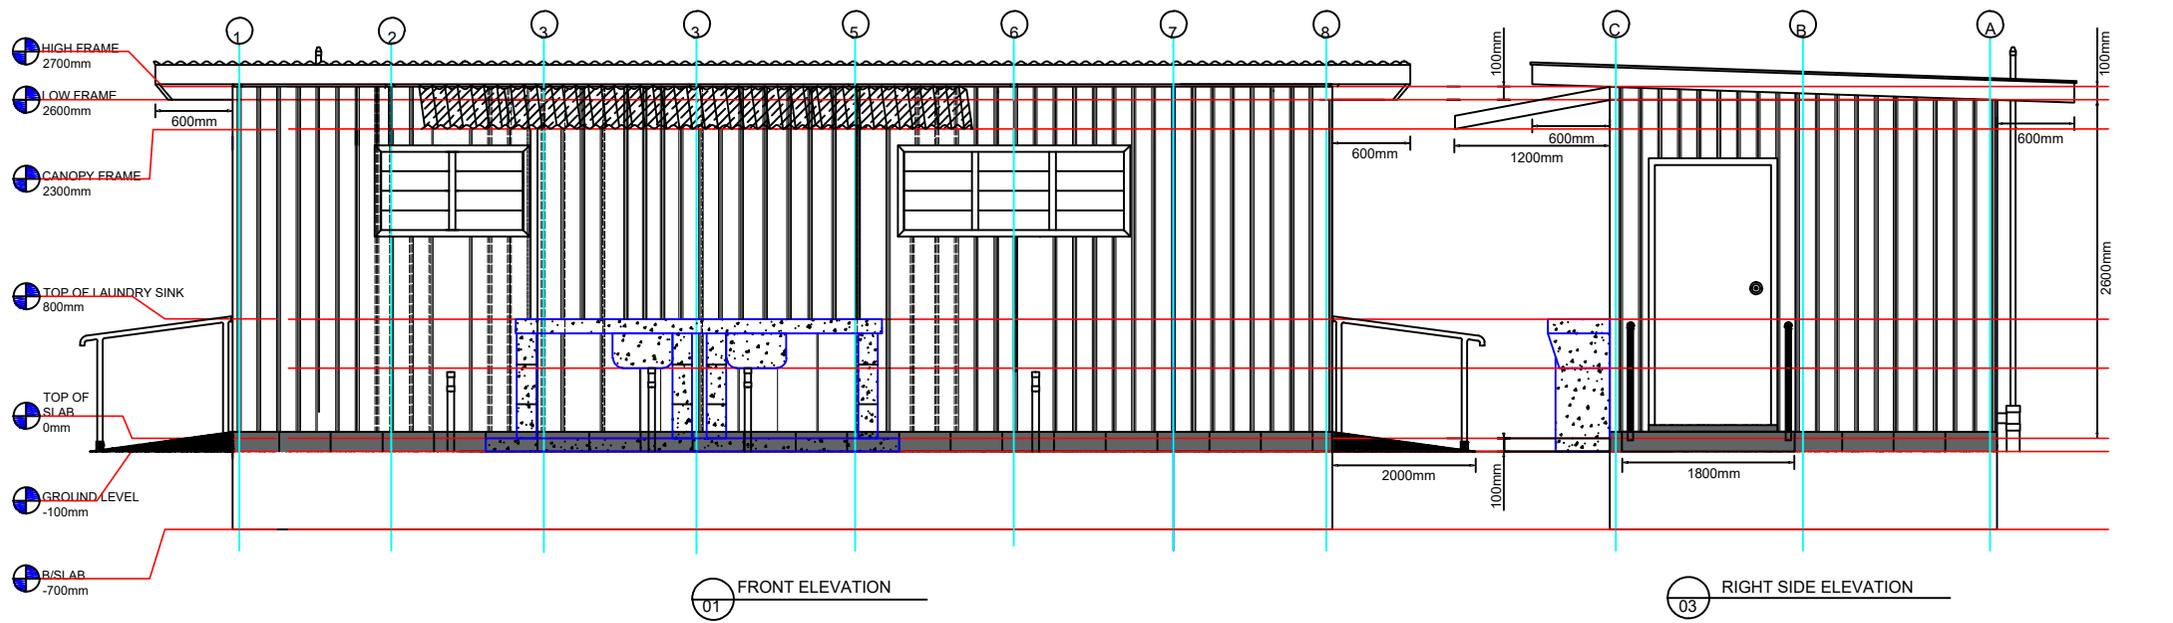


REV	DATE	BY	DESCRIPTION	CLIENT	CLIENT: UNICEF	SURVEYED:	Scale: Not to scale
			<ul style="list-style-type: none"> <li>- Wall structure frames - 4" x 2" timber (Akwa or Vitex)</li> <li>- External cladding - 26G colorbond corrugated profile iron sheet.</li> <li>- Internal cladding - 4.5mm fibro-board shoots</li> <li>- Shower room to be finished with tile</li> <li>- Shower room floor only</li> <li>- Shower room walls - up to 1.2m height only</li> </ul>		PROJECT: KOICA CLIMATE SMART	DESIGNED: I.Q.BRIAN	SHEETS: 2 OF 6
					PROJECT LOCATION: GUADALCANAL PROVINCE	DRAWN: I.Q.BRIAN	SHEETS SIZE: A4
					SITE: NUMBU	CHECKED: K.RODNEY	
					<b>Ablution Standard Plan:</b> 4 Toilet Cubicle and 3 Shower room with 2 Exterior Laundry Sink		

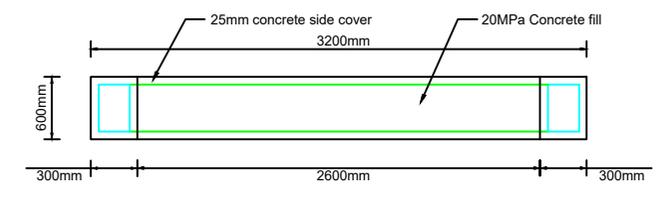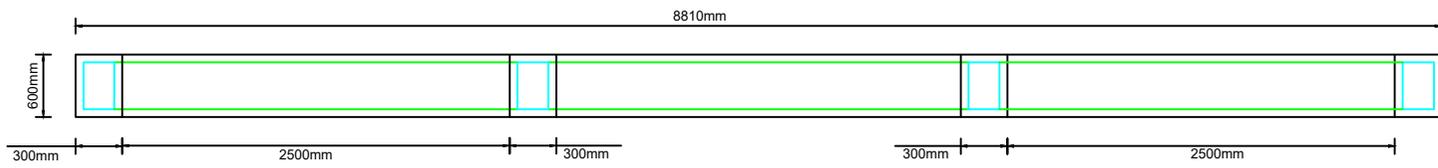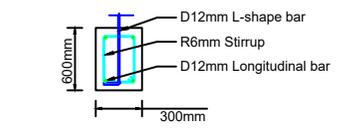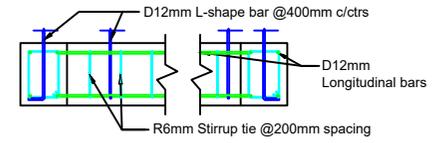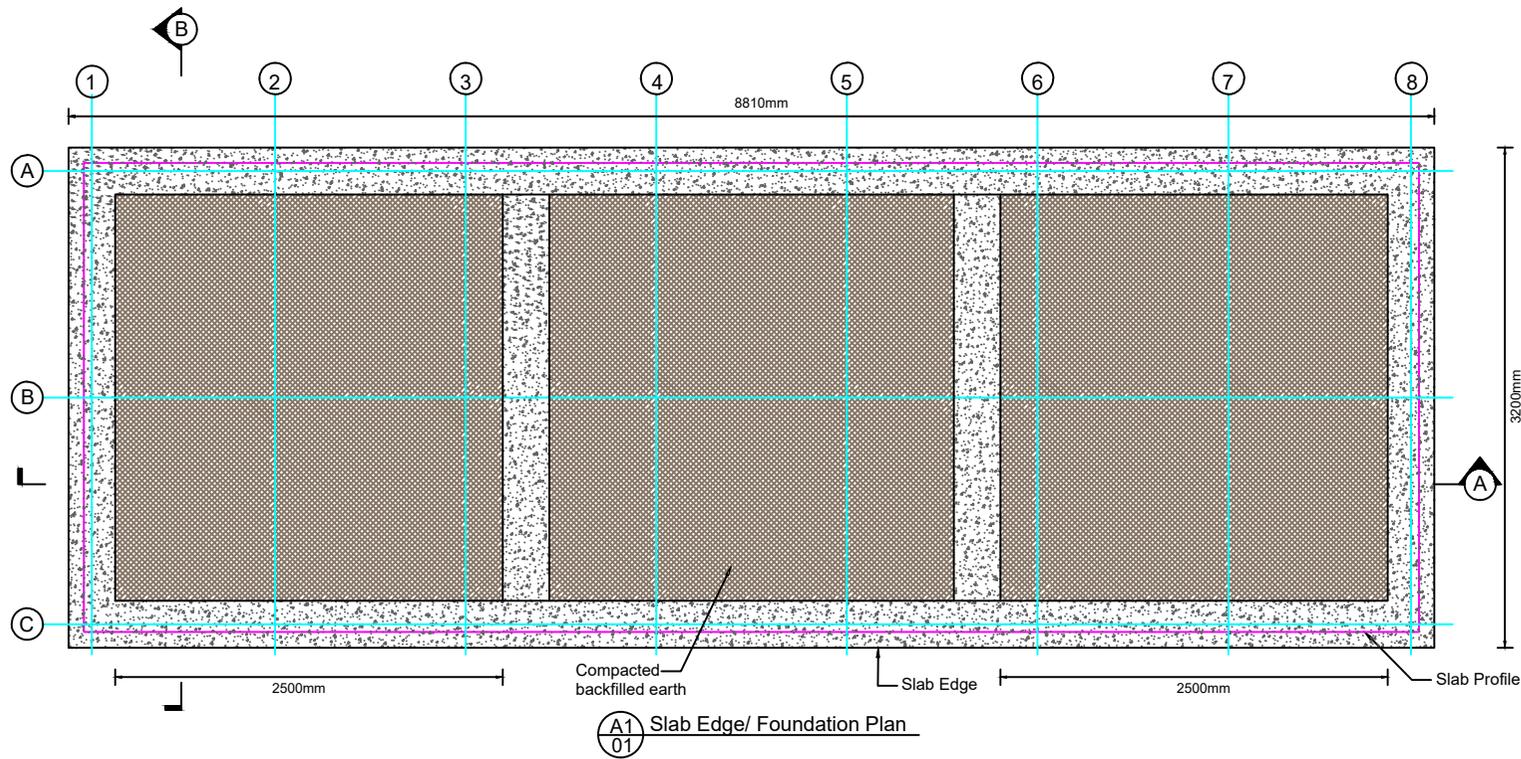


REV	DATE	BY	DESCRIPTION	CLIENT	CLIENT: UNICEF	SURVEYED:	Ablution Standard Plan: 4 Toilet Cubicle and 3 Shower room with 2 Exterior Laundry Sink	Scale: Not to scale	
					PROJECT: KOICA-CLIMATE SMART	DESIGNED: I.Q.BRIAN			SHEETS: 3 OF 6
					PROJECT LOCATION: GUADALCANAL PROVINCE	DRAWN: I.Q.BRIAN			SHEETS SIZE: A4
					SITE: NUMBU	CHECKED: K.RODNEY			

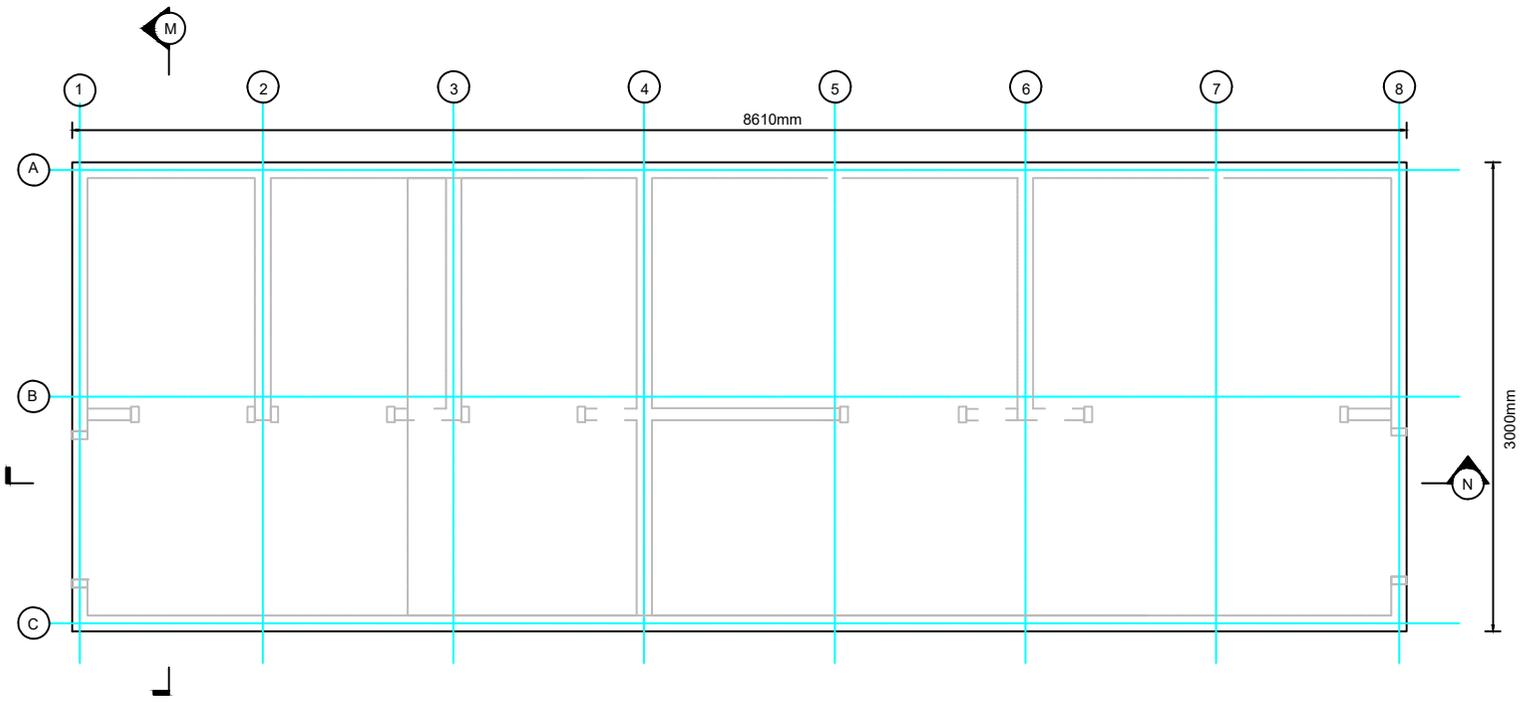

(A1) SLAB PLAN

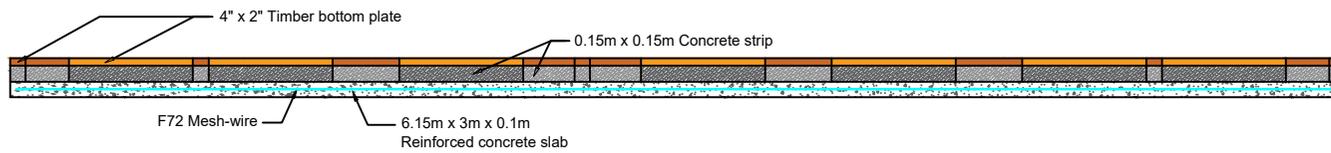


(03) Section N-N

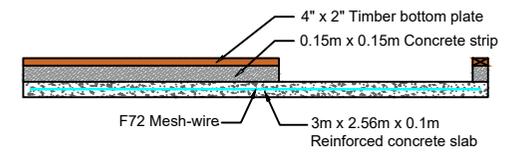

(02) Section M-M

REV	DATE	BY	DESCRIPTION	CLIENT	CLIENT: UNICEF	<b>Ablution Standard Plan:</b> 4 Toilet Cubicles and 3 Shower rooms with 2 Exterior Laundry Sinks	SURVEYED:			Scale: Not to scale	
					PROJECT: KOICA- CLIMATE SMART		DESIGNED: I.Q.BRIAN				SHEETS: 4 OF 6
					PROJECT LOCATION: GUADALCANAL PROVINCE		DRAWN: I.Q.BRIAN				SHEETS SIZE: A4
					SITE: NUMBU		CHECKED: K.RODNEY				

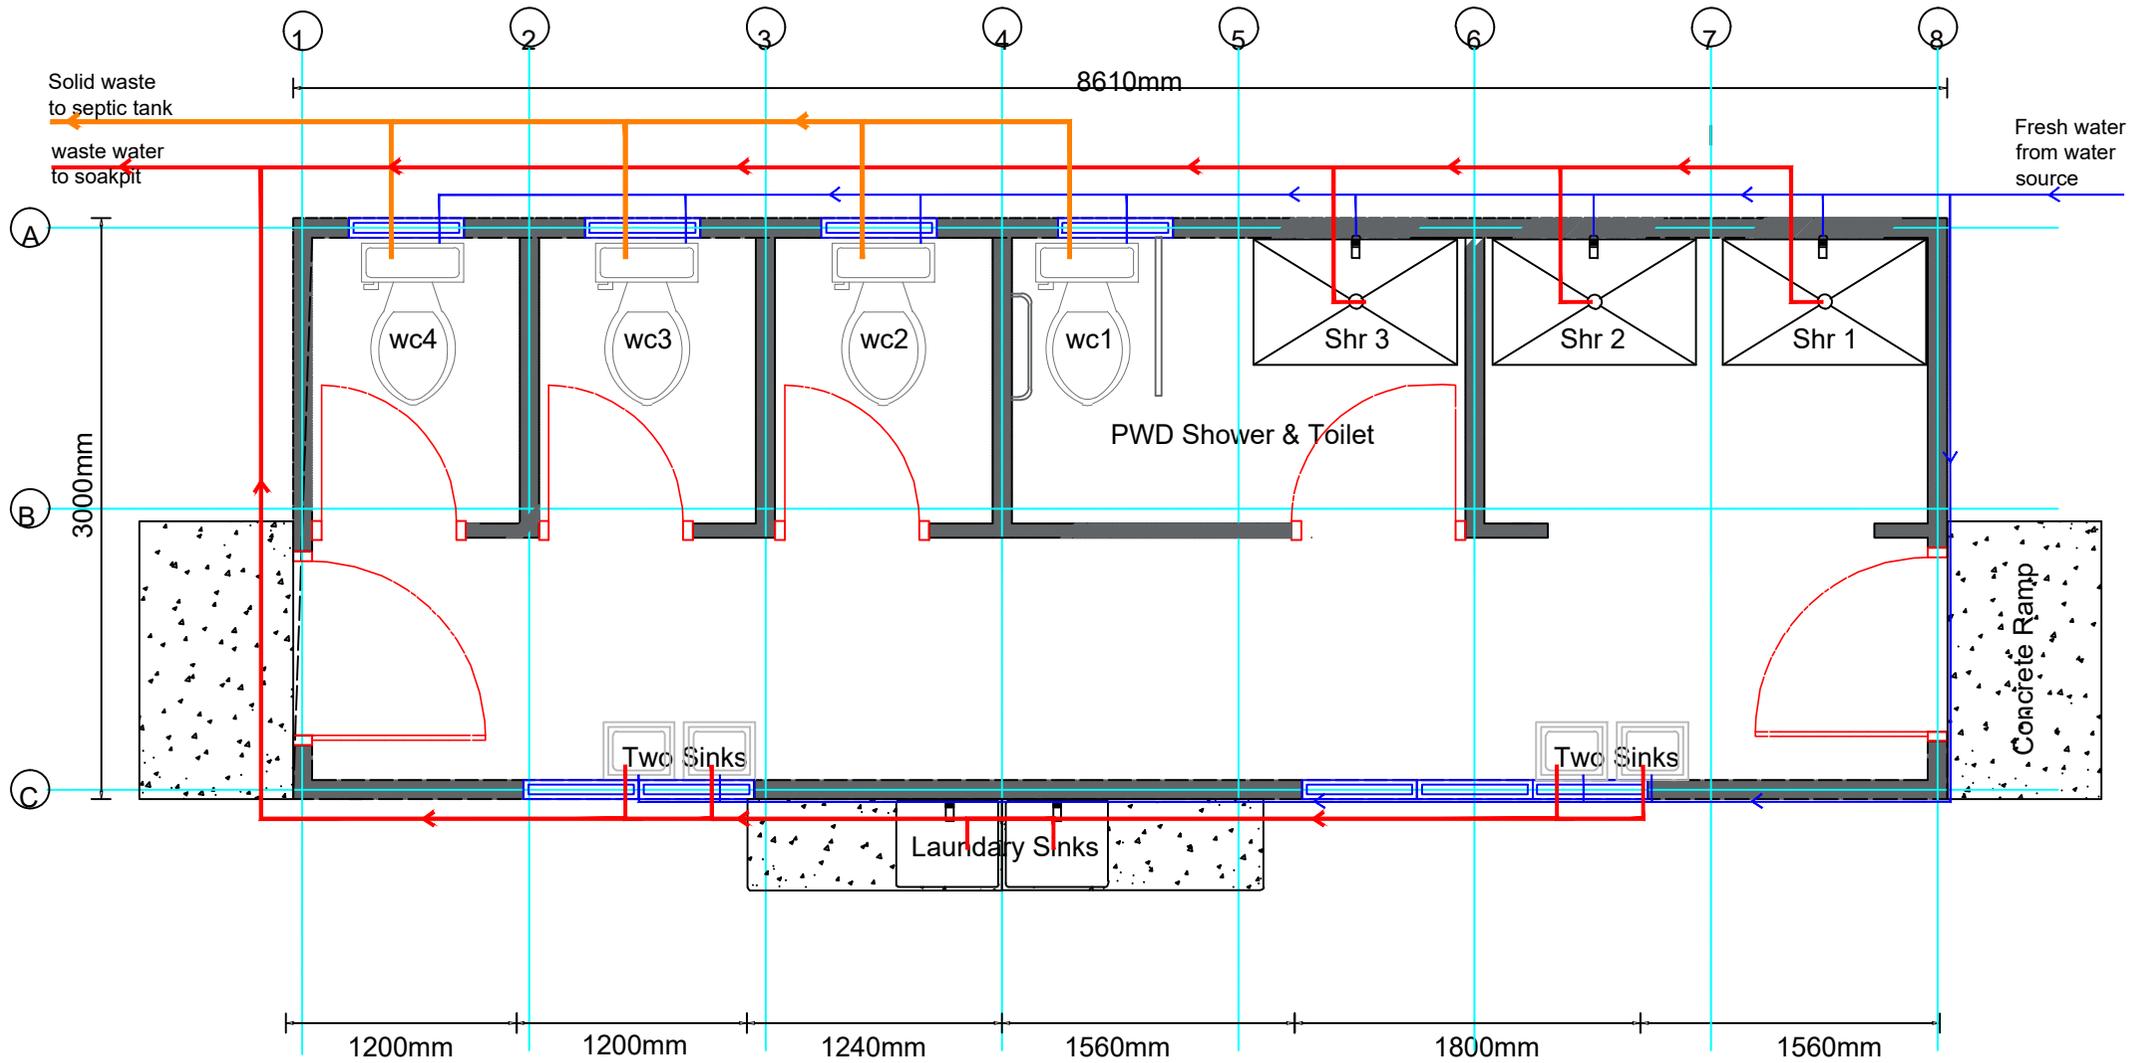

01 PLUMBING PLAN


- Solid waste Pipeline and Conenctions to septic tank
- Fresh water Pipeline & Connections
- Waste water Pipeline and Connections to soakpit

REV	DATE	BY	DESCRIPTION:	CLIENT:	CLIENT: UNICEF	SURVEY:		Scale: Not to scale
					PROJECT: KOICA- CLIMATE SMART	DESIGN: I.Q.BRIAN		SHEETS: 5 OF 6
					PROJECT LOCATION: GUADALCANAL PROVINCE	DRAWN: I.Q.BRIAN		SHEETS SIZE: A4
					SITE: NUMBU	REVISED: K.RODNEY		

**Ablution Standard Plan:**  
 4 Toilet Cubicle and 3  
 Shower room with 2 Exterior  
 Laundry Sink

**KEY**

-  Switch Board
-  Electrical Wiring
-  Light switch
-  10W external lights
-  10W LED lights

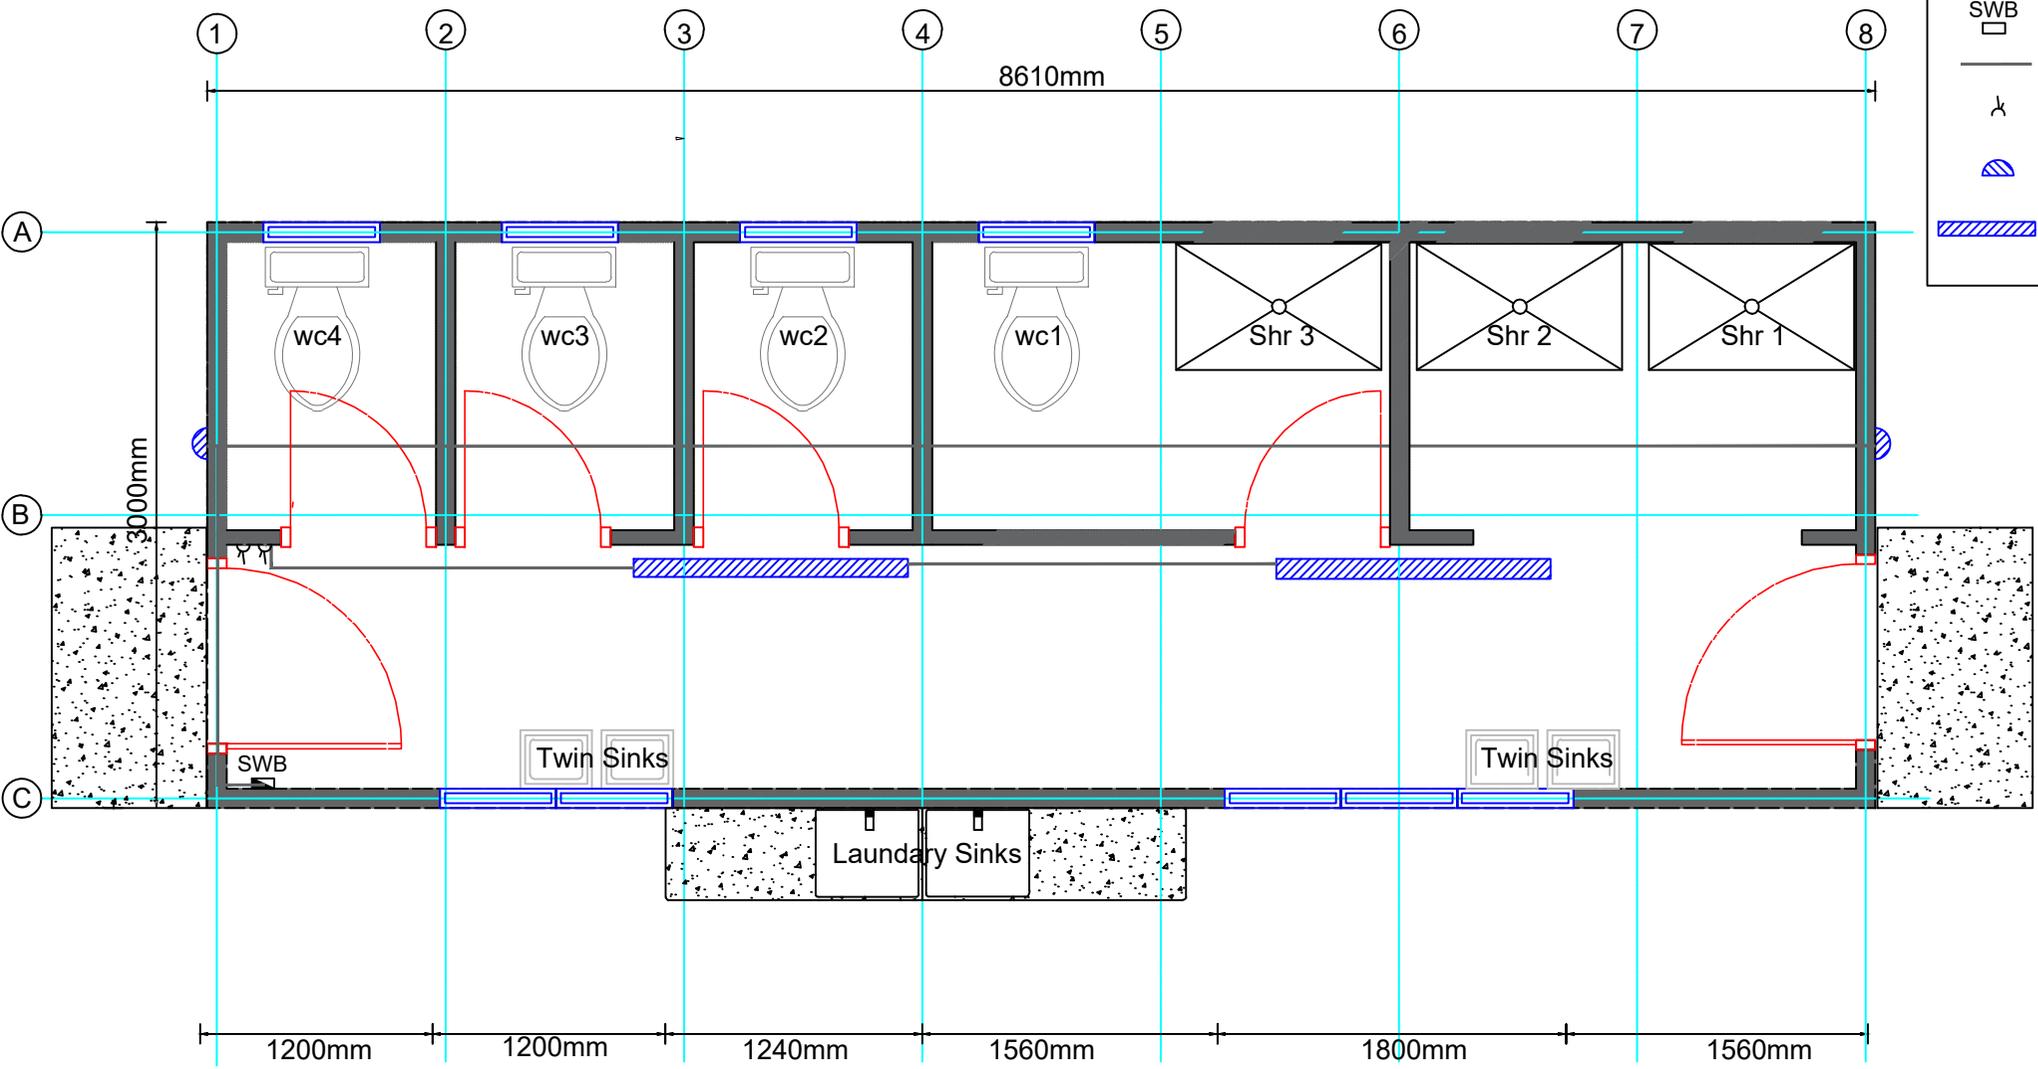

- 01 ELECTRICAL PLAN  
NTS

REV	DATE	BY	DESCRIPTION:	CLIENT:	CLIENT: UNICEF	SURVEY:			Scale: Not to scale
					PROJECT: KOICA- CLIMATE SMART	DESIGN: I.Q.BRIAN			SHEETS: 6 OF 6
					PROJECT LOCATION: GUADALCANAL PROVINCE	DRAWN: I.Q.BRIAN			SHEETS SIZE: A4
					SITE: NUMBU	REVISED: K.RODNEY			

**Ablution Standard Plan:**  
4 Toilet Cubicle and 3  
Shower room with 2 Exterior  
Laundry Sink